


RUSSELL M. ESTELLE  
 REDCROSS  
 (17-114)  
 PG. 10, PG. 128

N/F  
 JAU JENG WANG  
 (17-116)  
 DB 234, PG. 84 (PLAT)  
 (SEE DRAWING NO.  
 7553-24)

N/F  
 ADA DIXON EST.  
 (17-118)  
 DB. 45, PG. 102

N/F  
 JAU JENG WANG  
 (17-112)  
 DB 445, PG. 691  
 (SEE DRAWING NO.  
 7553-26)

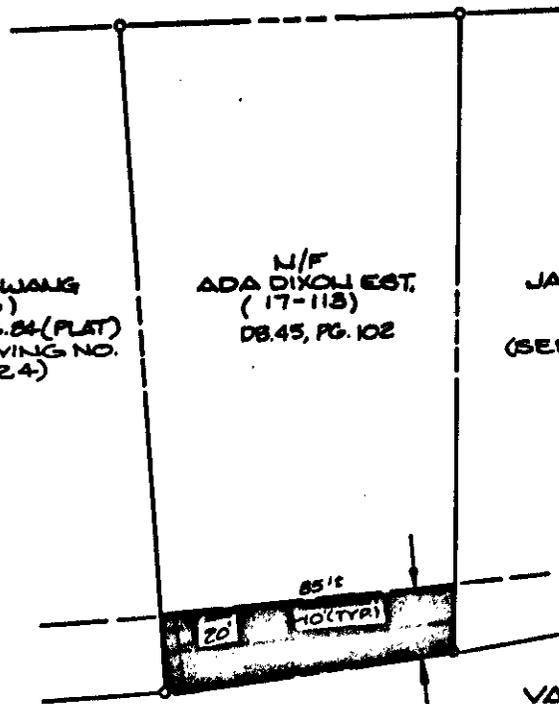

ROUTE 238

VARIABLE WIDTH  
 PERMANENT UTILITY  
 EASEMENT  
 1,700 S.F. ±  
 0.04 AC. ±

**NOTE:** PROPERTY LINES SHOWN ARE TAKEN FROM  
 RECORD AND OTHER AVAILABLE INFORMATION  
 AND DO NOT REPRESENT AN ACTUAL FIELD SURVEY.

SEE SHEET #14 OF LACKEY WASTEWATER  
 SYSTEM - PHASE I FOR PLAN AND PROFILES.



Consulting Engineers

Engineers, Surveyors, Planners

Williamsburg, Virginia

**PLAT SHOWING VARIABLE WIDTH EASEMENT  
 THROUGH THE LANDS OF ADA DIXON EST.  
 TO: THE COUNTY OF YORK**

NELSON DISTRICT

YORK COUNTY

VIRGINIA

Scale: 1" = 50'

Ref.: NOTED

Date: 8/14/91

Job No.: 7553-25